


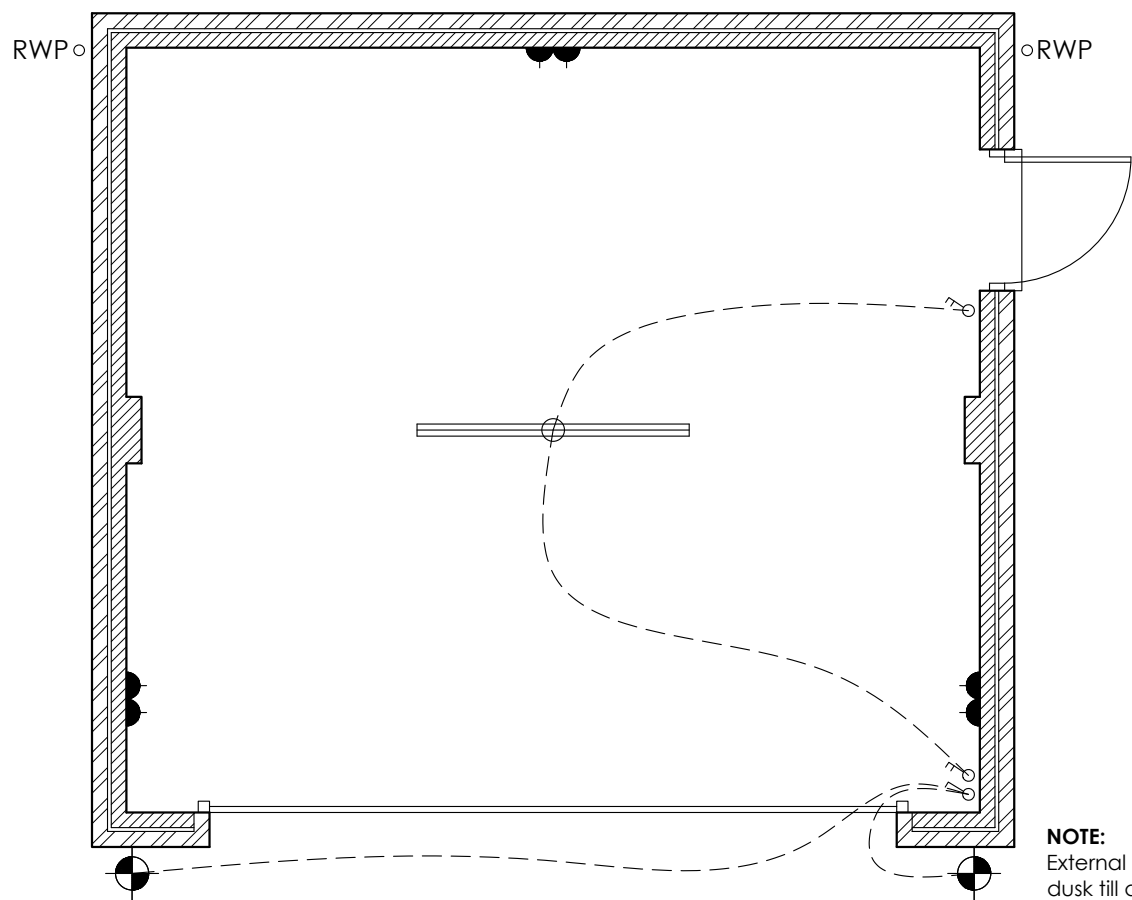

NOTE:
External up and downlighters with dusk till dawn sensors

ELECTRICAL LAYOUT KEY

- LOW LEVEL TWIN 13AMP SOCKET
- MID LEVEL TWIN 13AMP SOCKET
- HIGH LEVEL TWIN 13AMP SOCKET
- LOW LEVEL SINGLE 13AMP SOCKET
- GROUPED GRID SWITCH
- FUSED SPUR
- LOW LEVEL POWER OUTLET FROM GRID SWITCH
- MECHANICAL EXTRACT VENTILATOR
- DIGITAL TV POINT
- HIGH LEVEL DIGITAL TV POINT
- TELEPHONE OUTLET
- AUDIO ENTRY PHONE
- EXTRACTOR FAN ISOLATOR SPUR LOCATED CENTRALLY ABOVE DOOR EXTERNALLY
- PENDANT LIGHT FITTING WITH LOW ENERGY BULB
- EXTERNAL LIGHT (LOW ENERGY BULB DAYLIGHT CUT-OFF)
- BATTEN HOLDER LIGHT FITTING WITH LOW E BULB
- DOWNLIGHTER WITH LOW ENERGY BULB
- WALL LIGHT
- EXTERNAL TAP
- SHAVER SOCKET
- CARBON MONOXIDE DETECTOR
- DOOR BELL
- USB SOCKET
- MEDIA PLATE WITH MASTER BT SOCKET
- RADIATOR
- HEATED TOWEL RAIL
- CARBON MONOXIDE DETECTOR
- HEAT DETECTOR
- SMOKE DETECTOR
- LIGHT SWITCH
- 2-WAY SWITCH
- GAS POINT
- COOKER POINT
- ROOM THERMOSTAT
- CONSUMER UNIT
- MIXER SHOWER
- IMMERSION HEATER SWITCH
- ELECTRICITY METER
- UNIBOX GAS METER
- 6FT LED STRIP LIGHT

REVISION	DATE	DRAWN	DESCRIPTION
CLIENT	RTW Construction & Developments Ltd	DRAWN OS	PROJECT DESIGNER KB
PROJECT	Proposed residential development on land off Cobgate, Whaplode	DATE 08.05.2024	SCALE 1:50
DRAWING	Double Garage - M&E Layout Plots 13, 14, 21, 27	DRAWING NUMBER	544.DG2.WD.02



KING'S LYNN INNOVATION CENTRE,
INNOVATION DRIVE, KING'S LYNN,
PE30 5BY
T: 01553 970033
E: design@studio11architecture.co.uk
W: www.studio11architecture.co.uk