

NOTES: -


GRID NATIONAL

LEVELS ARE RELATIVE TO OSBM 3.877Z

KEY: -

- BT BRITISH TELECOM
- EP ELECTRICITY POLE
- FH FIRE HYDRANT
- G GULLY
- IC INSPECTION COVER
- IP LAMPPOST
- LM MANHOLE
- CL COVER LEVEL
- IL INVERT LEVEL
- IS STOP LAP
- SV TELEPHONE POLE
- TP GAS VALVE
- RWP RAIN WATER PIPE
- KO KERB OUTLET
- MK MARKER
- WO WASTE OUTLET
- FFL FINISHED FLOOR LEVEL
- WM WATER METER
- BO BOLLARD
- RP REFLECTOR POST

ALL COVERS SHOWING INVERT LEVELS HAVE BEEN LIFTED. PIPE SIZES, DIRECTION OF FLOW AND TYPE ARE DETERMINED FROM ALL AVAILABLE INFORMATION BUT ARE NOT PROVEN.

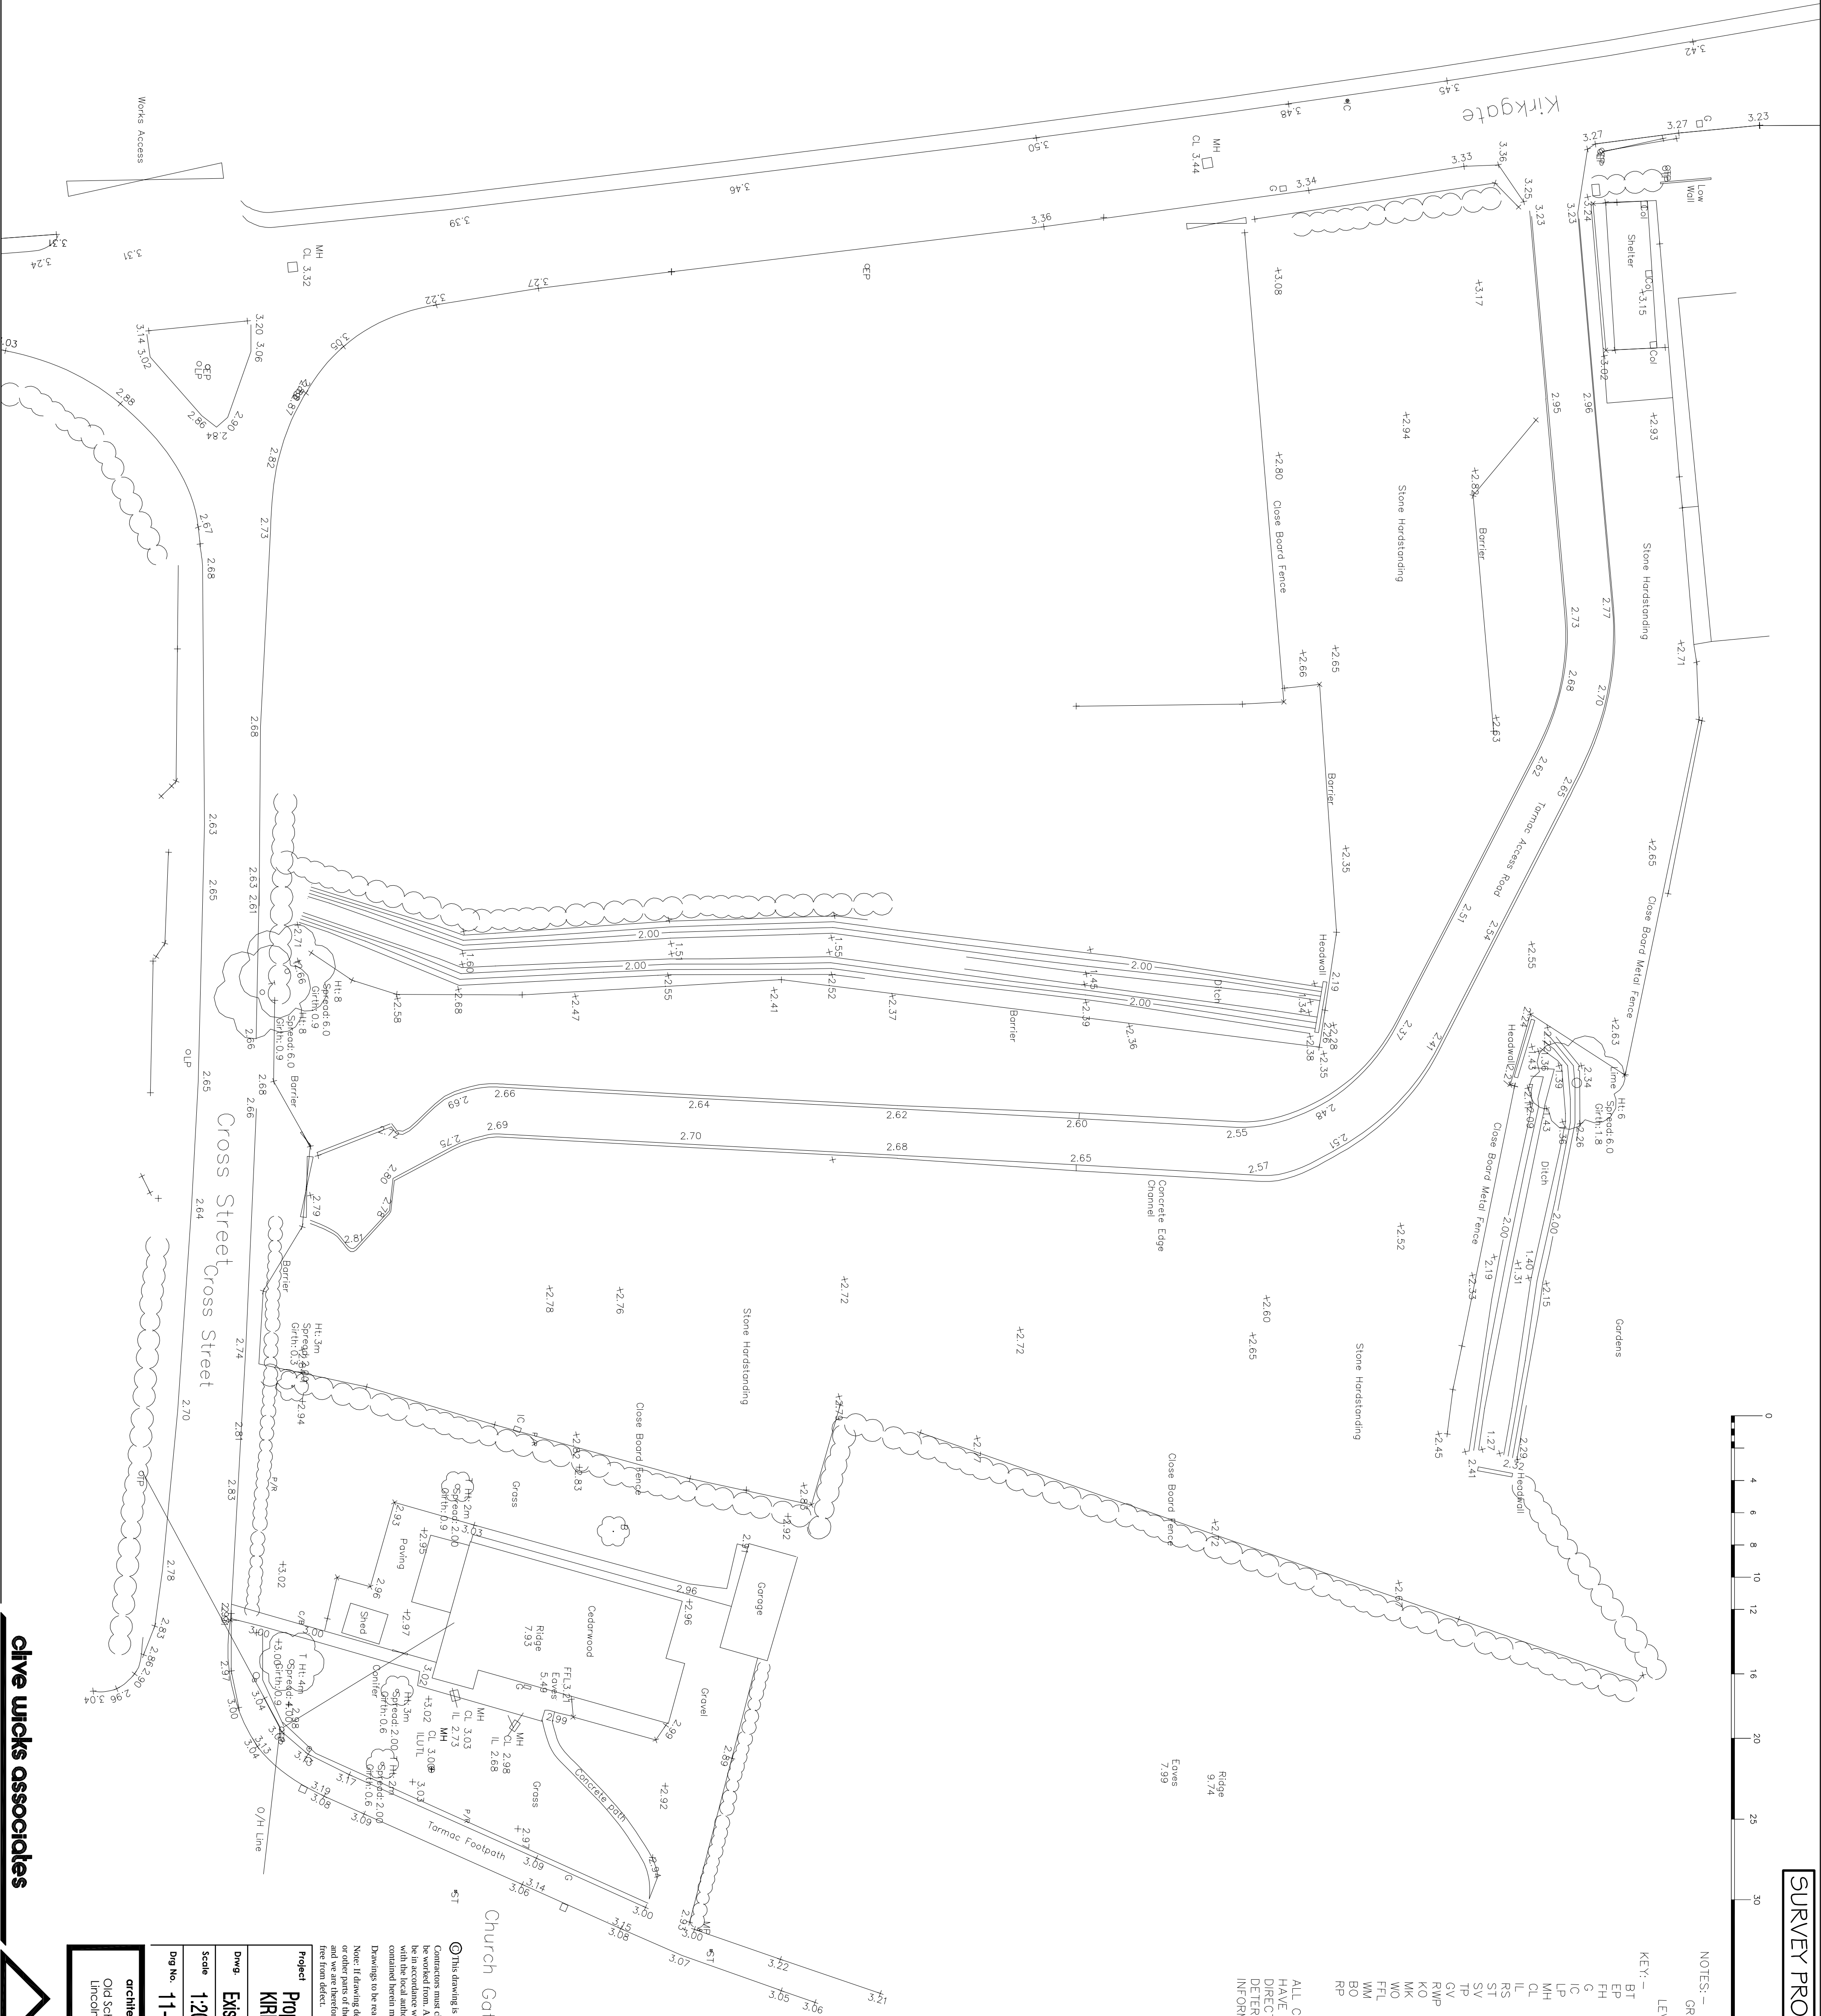

Church Gate

© The drawing is copyright

Consultants must check all dimensions on Site. Only figured dimensions are to be worked from. Any foundation depths indicated are indicative only and must be in accordance with the consulting engineers design and/or agreed on site. Dimensions shown on this drawing are for information only and are not to be used for construction purposes. Dimensions shown must be reported to the Architect before work proceeds.

Drawings to be read with Engineers calculations / report where applicable.

Note: If drawing details existing structures, we have not inspected work and we are therefore unable to report that any such part of the property is free from defect.

Project
Proposed Residential Development
KIRKGATE/ CROSS ST WHAPLODE

DWG.
Existing Site Plan (Amended Scheme)

Scale
1:200 @ A1

Date
Sept. '15

Dwg No.
11-2078- 100

Rev.
-

architects • designers • planning consultants
Old School House • 36 Boston Road • Stedford
Lincolnshire • NG34 7EZ • Tel:01529 414141
Fax: 01529 419757

clive wicks associates