

NOTES: -


GRID NATIONAL

LEVELS ARE RELATIVE TO OSBM 3.877Z

KEY: -

- BT BRITISH TELECOM
- EP ELECTRICITY POLE
- FH FIRE HYDRANT
- G GULLY
- IC INSPECTION COVER
- IP LAMPPOST
- LM MANHOLE
- CL COVER LEVEL
- IL INVERT LEVEL
- IS STOP LAP
- SV TELEPHONE VALVE
- TP GAS WASTE POLE
- RWP RAIN WATER PIPE
- KO KERB OUTLET
- MK MARKER
- WO WASTE OUTLET
- FFL FINISHED FLOOR LEVEL
- WM WATER METER
- BO BOLLARD
- RP REFLECTOR POST

ALL COVERS SHOWING INVERT LEVELS HAVE BEEN LIFTED. PIPE SIZES, DIRECTION OF FLOW AND TYPE ARE DETERMINED FROM ALL AVAILABLE INFORMATION BUT ARE NOT PROVEN.

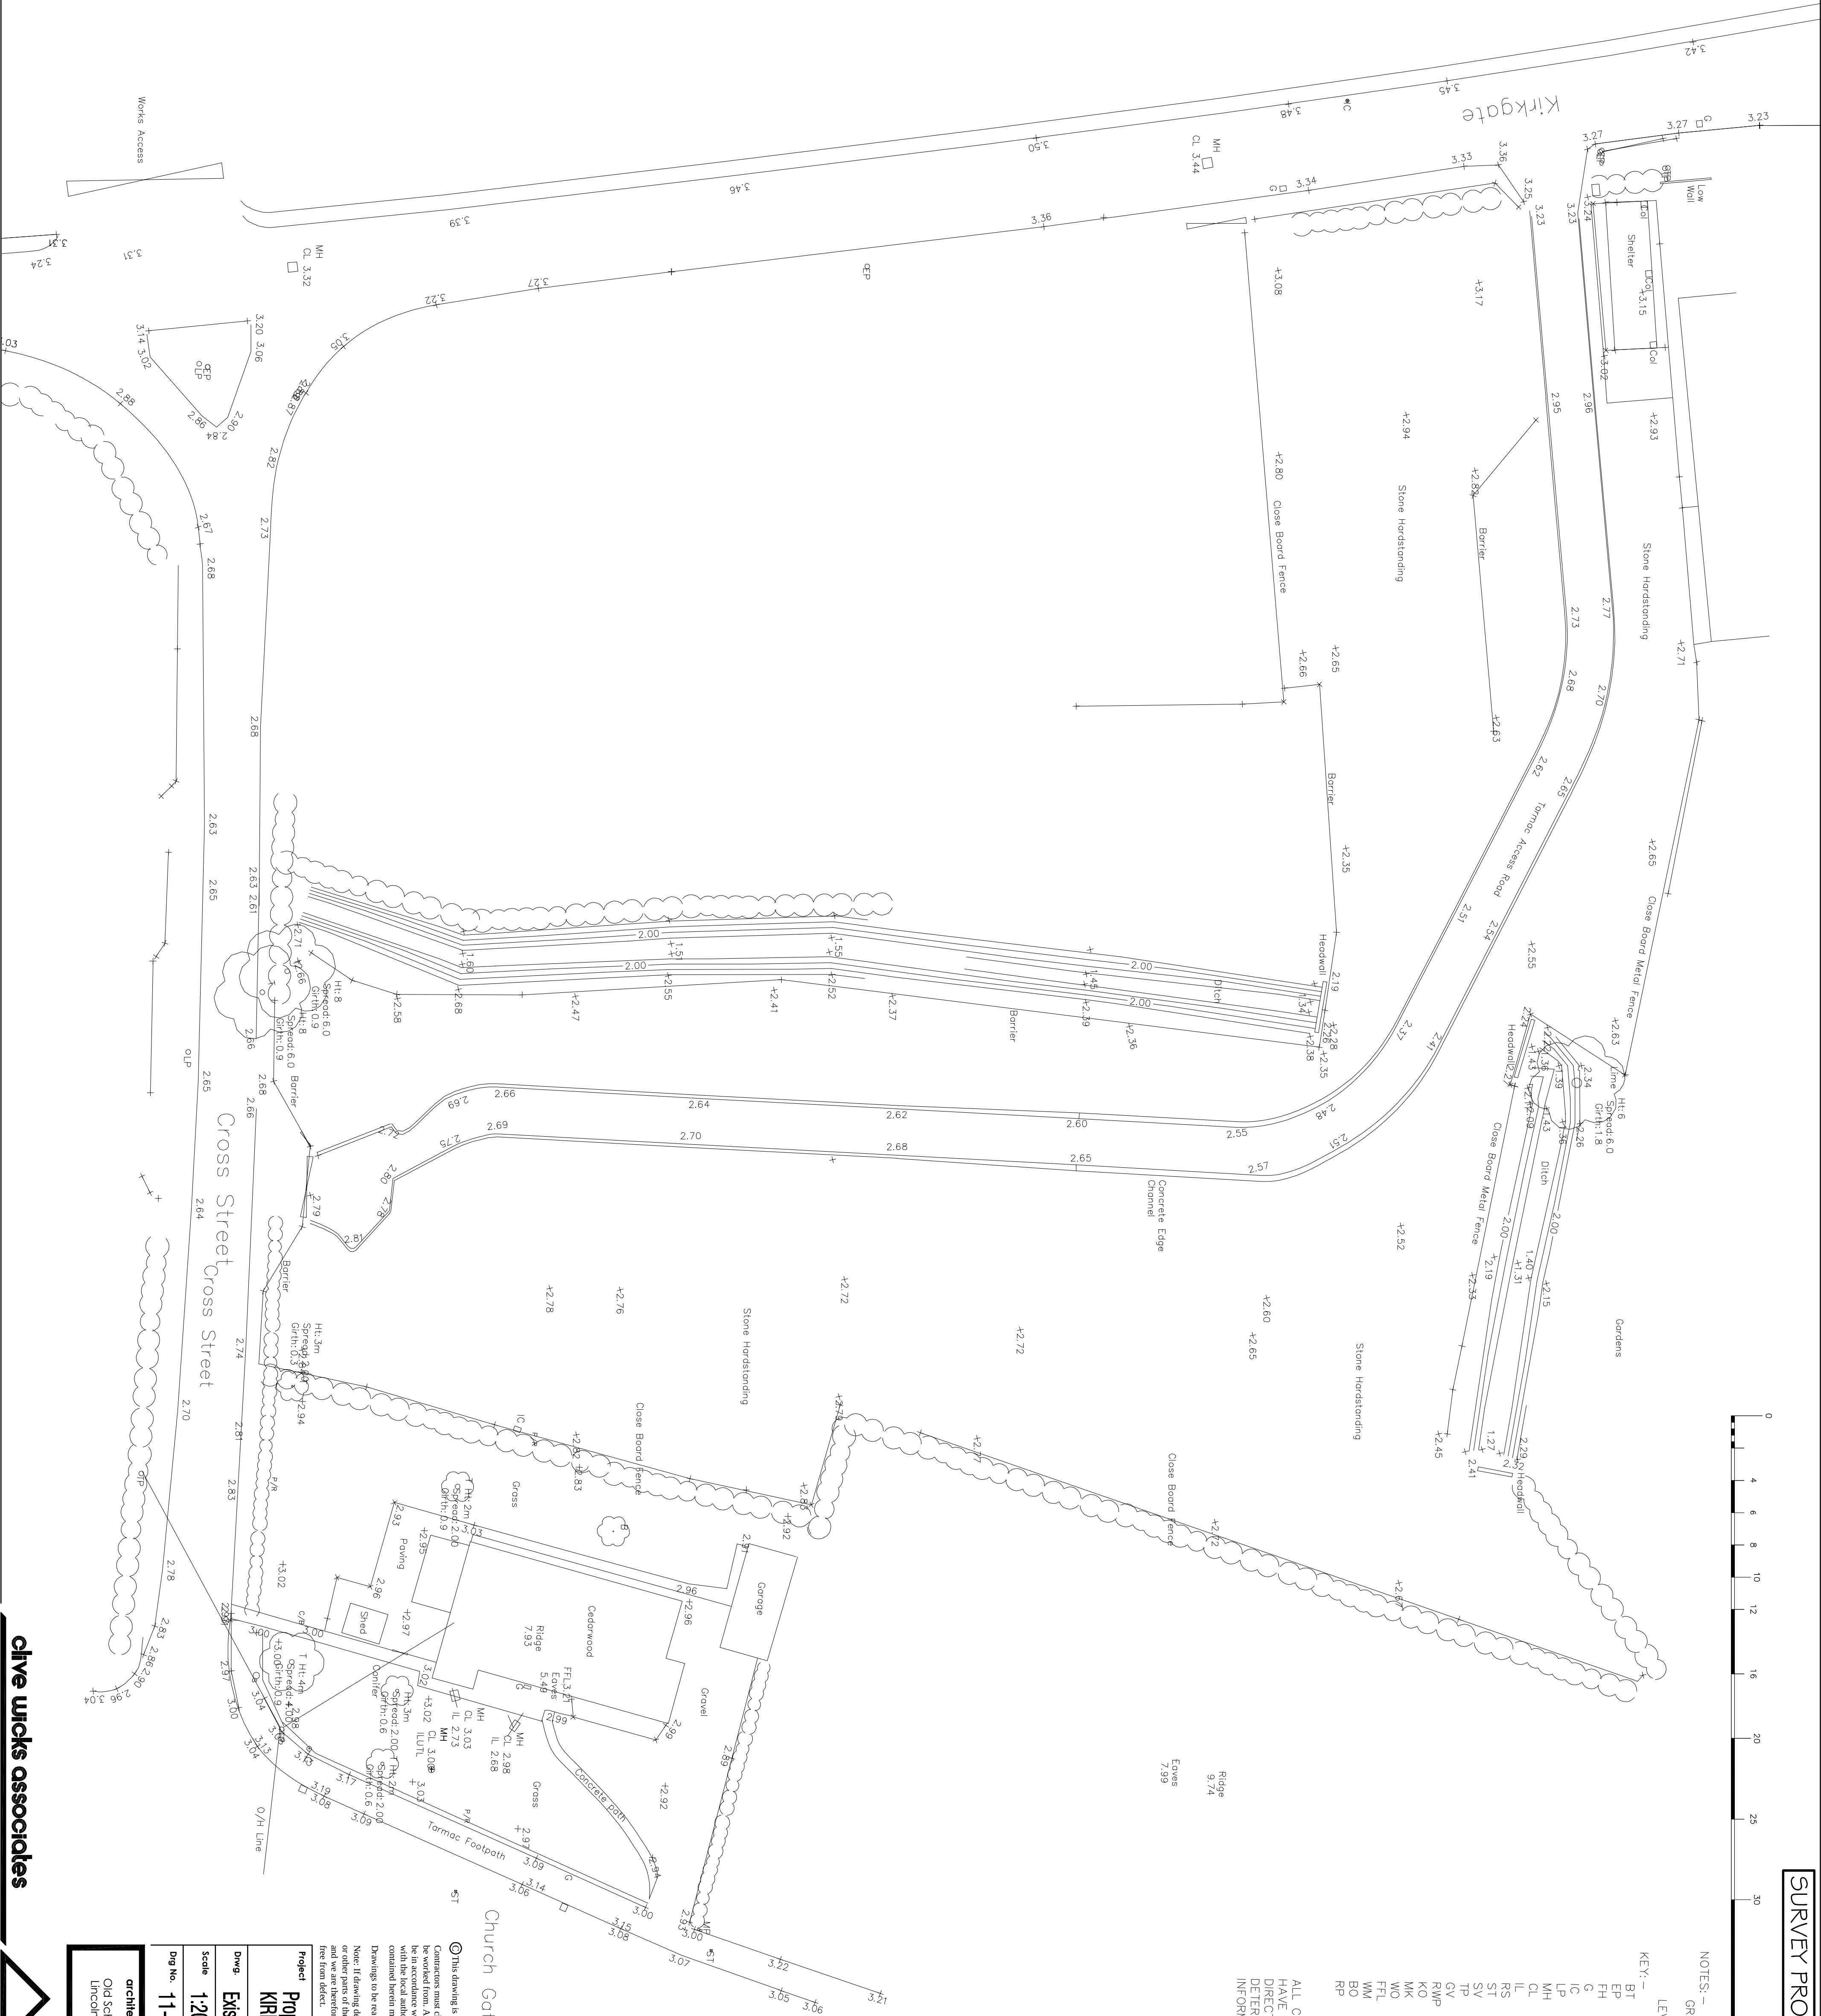

Church Gate

© The drawing is copyright

Consultants must check all dimensions on Site. Only figured dimensions are to be worked from. Any foundation depths indicated are indicative only and must be in accordance with the consulting engineers design and/or agreed on site. The drawing is not to be used for any other purpose without the written permission of the consulting engineers. Dimensions shown on this drawing are not to be used for any other purpose without the written permission of the consulting engineers.

Note: If drawing details existing structures, we have not inspected work and we are therefore unable to report that any such part of the property is free from defect.

Project
Proposed Residential Development
KIRKGAITE/ CROSS ST WHAPLODE

DWG.
Existing Site Plan (Amended Scheme)

Scale
1:200 @ A1

Date
Sept. '15

Dwg No.
11-2078- 100

Rev.
-

architects • designers • planning consultants
Old School House • 36 Boston Road • Stedford
Leicestershire • NG34 7EZ • Tel:01529 414141
Fax: 01529 419757

clive wicks associates